




SECTION A-A
Scale 1:20

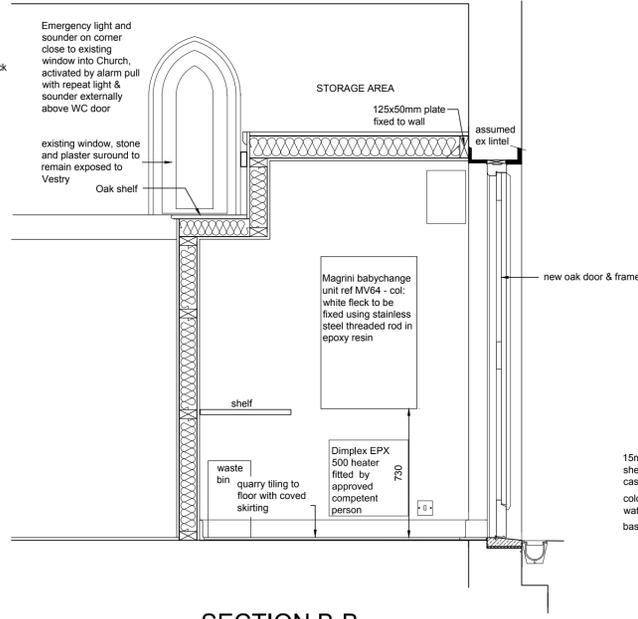

SECTION B-B
Scale 1:20

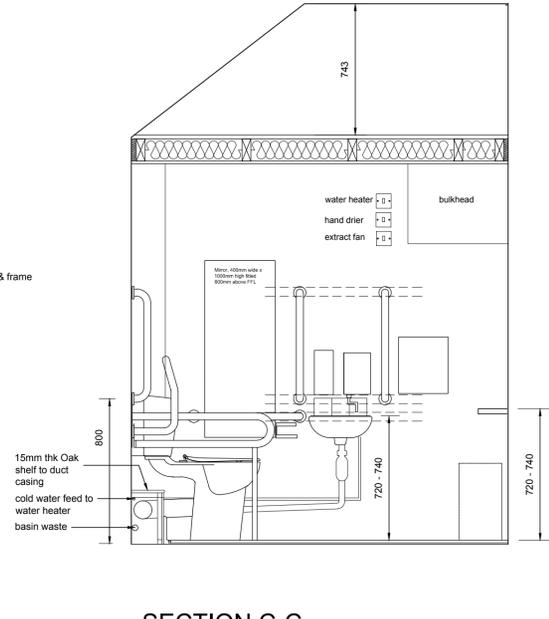


SECTION C-C
Scale 1:20

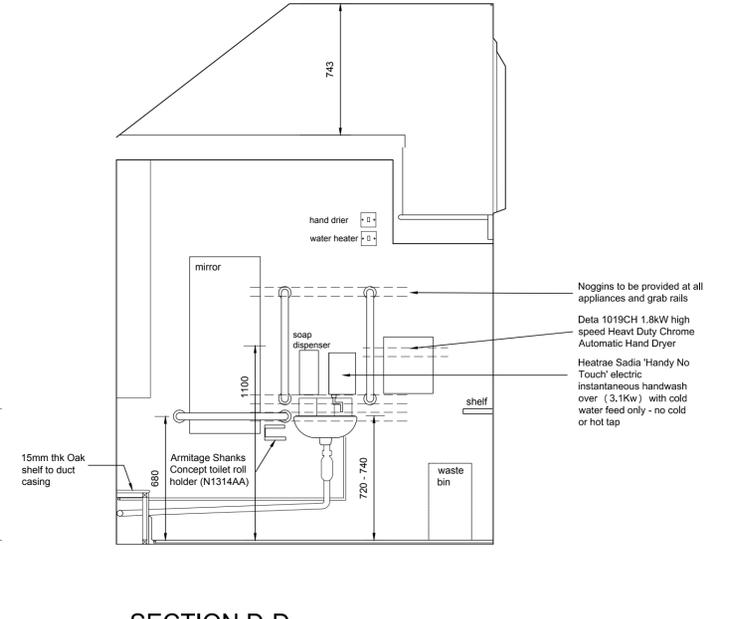



SECTION D-D
Scale 1:20

ELECTRICAL LEGEND

- (B.H) Bulkhead - ceiling mounted
- Fused switched spur outlet positioned at high level unless stated otherwise
- Wall mounted light fitting

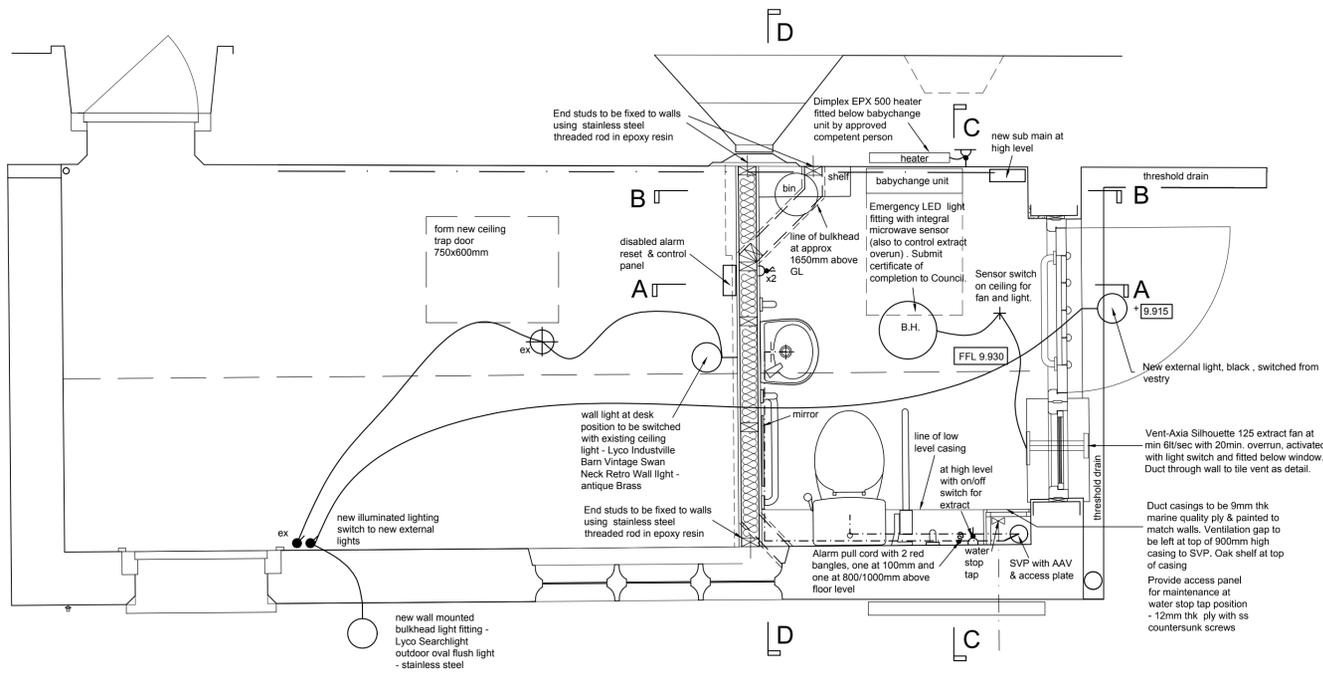

PLAN
Scale 1:20

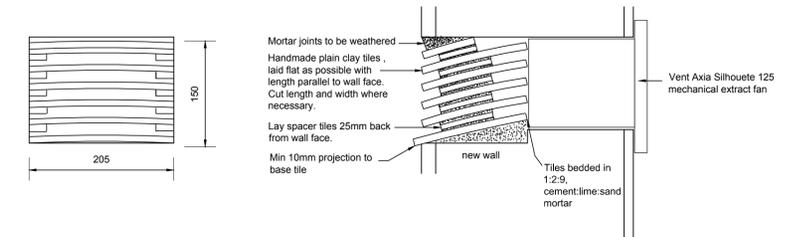 

TILE VENT DETAIL
Scale 1:5

SANITARYWARE SCHEDULE

- DOC M PACK - Nymas Close coupled Doc M pack with steel grab rails, TWV3 valve. Ref: DM700K/Iconcealed fittings. Colour DB
- Comprises
- 6x 600mm steel grab rails
- 1x 800mm lift & lock steel hinged rail (not to be fitted)
- 1x close coupled WC pan & cistern assembly
- 1x ring only toilet seat with stainless hinge(not to be fitted)
- 1x two tap hole basin & fittings
- 1x basin mixer tap (not to be fitted)
- 1x cistern spatula lever
- 1x TMV3 in-line thermostatic valve
- NymaPRO Trombone lift and lock steel hinged rail with leg Ref DDGR-BP800mm. Colour DB
- Nymas toilet seat with lid, stainless pillar hinge. Ref 26006. Colour DB
- Nymas anti bacterial duraplant colostomy bag shelf Ref 140201 - Colour White
- Nymas soap dispenser Ref 260401. Stainless steel
- Hand Dryer - Delta 1019CH 1.8kW high speed Heavy Duty Automatic - Chrome finish
- Armitage Shanks Concept toilet roll holder (N1314AA)
- Mirror - 400x1000mm with bevelled edge fitted to back of door using dome headed screws fixed to oak battens
- Waste bin - Contractors choice
- Coat hook - Contractors choice
- Nymas Tel:01642 710719 www.nymas.co.uk

DAVIDWHYMARK
ARCHITECTURE & CONSERVATION
The Studio, Slackwood Road, Polstead, Colchester CO6 5BA
Tel & Fax: 01473 827200 Mobile: 07976 763230
E-mail: info@suffolk-architects.com Website: www.suffolk-architects.com

Client: The PCC of St Mary's Church, Great Blakenham
Project: Vestry Re-ordering & New Kitchen
Title: Proposed Vestry Plan & Sections
Do not scale from this drawing

Revisions:	A	Date:	Aug 17	Drawn by:	MI	Scale(s):	1:20 at A2	Drawing no.:	05
	B								
	C								